

STATE	PROJECT NUMBER	SHEET NO.	TOTAL SHEETS
GA.	STP-0005-00(893)	66	92



MATCHLINE  
SEE COMMUNICATIONS PLAN  
SHEET 4 OF 7


INSTALL:  
F/D SNOWSHOE (2 EA)  
OSP, F/D CABLE, LOOSE TUBE, SM, 12 FIBER (SAVS-S002)  
MAINTENANCE COIL (100 LF)

FROM POLE 4-5 ON SHEET 4 OF 7 TO POLE 7-14 THIS SHEET  
REMOVE:  
TRAFFIC CABLE (LS)  
INSTALL:  
STEEL WIRE STRAND CABLE, 1/4" (1480 LF)  
OSP, F/D CABLE, LOOSE TUBE, SM, 12 FIBER (SAVS-S002) (1780 LF)  
LASH F/D CABLE TO STEEL WIRE STRAND CABLE.


PROPOSED CONTROLLER #30  
INSTALL:  
FIBER OPTIC CLOSURE, FDC (WALL-MOUNTED)  
6 FIBER (1 EA)  
FROM POLE 7-14 TO PULL BDX  
INSTALL:  
CONDUIT, NONMETL, TP 2, 2 IN (10 LF)  
OSP, F/D CABLE, DROP, SM, 6 FIBER (55 LF)  
F/D QUANTITY INCLUDES 20 LF COIL IN PULL BDX  
FROM PULL BDX TO CONTROLLER CABINET  
INSTALL:  
CONDUIT, NONMETL, TP 2, 2 IN (5 LF)  
OSP, F/D CABLE, DROP, SM, 6 FIBER (10 LF)  
F/D QUANTITY INCLUDES 5 LF COIL IN CABINET BASE

INSTALL:  
F/D SNOWSHOE (2 EA)  
OSP, F/D CABLE, LOOSE TUBE, SM, 12 FIBER  
MAINTENANCE COIL (100 LF)

INSTALL:  
F/D CLOSURE, AERIAL (SEALED) 6 FIBER (1 EA)  
F/D SPLICE, FUSION (4 EA)  
F/D SNOWSHOE (1 EA)  
FROM AERIAL CLOSURE TO SNOWSHOE  
INSTALL:  
OSP F/D CABLE, LOOSE TUBE, SM, 12 FIBER (SAVS-S002)  
AERIAL SPLICING COIL (100 LF)  
FROM AERIAL CLOSURE TO POLE 7-14  
INSTALL:  
OSP, F/D CABLE, DROP, SM, 6 FIBER (55 LF)

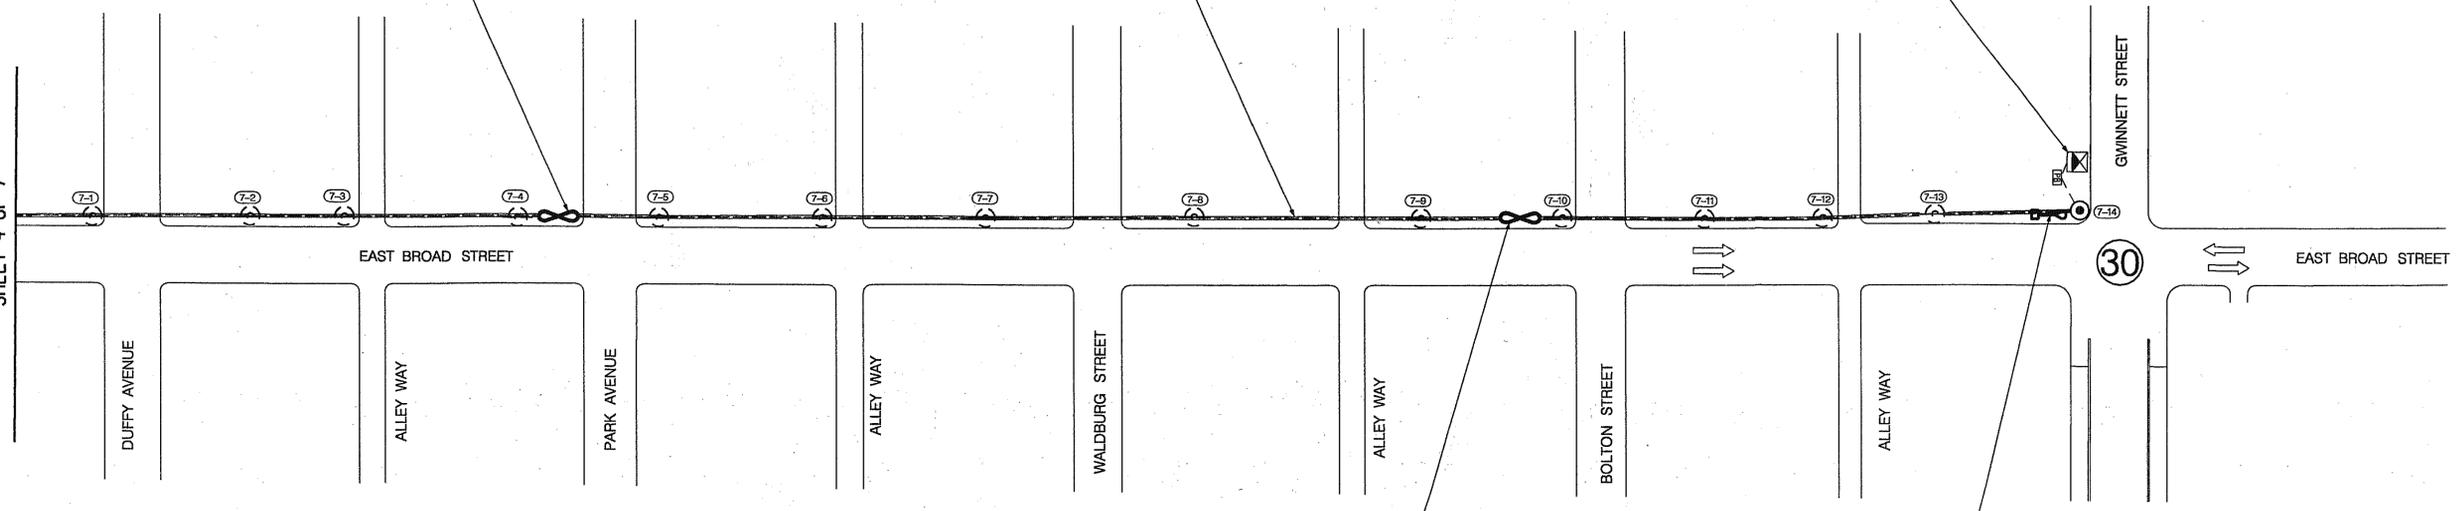

REVISIONS					
DATE	BY	DESCRIPTION	DATE	BY	DESCRIPTION

 

NAME	DATE	NAME	DATE
DESIGNED BY: EKN	01 /03	FIRST DRAWN: NDH	01 /03
CHECKED BY: ENW	10 /03	LAST DRAWN: RDG	10 /03

GEORGIA  
DEPARTMENT OF TRANSPORTATION

COMMUNICATIONS PLAN  
SHEET 7 OF 7

ACCOUNT NO.
DRAWING NO.