


RELEASED FOR CONSTRUCTION - 12/05/11

SEE DWG. NO. 25-003 FOR CONTINUATION
SEE DWG. NO. 23-03 FOR CONTINUATION

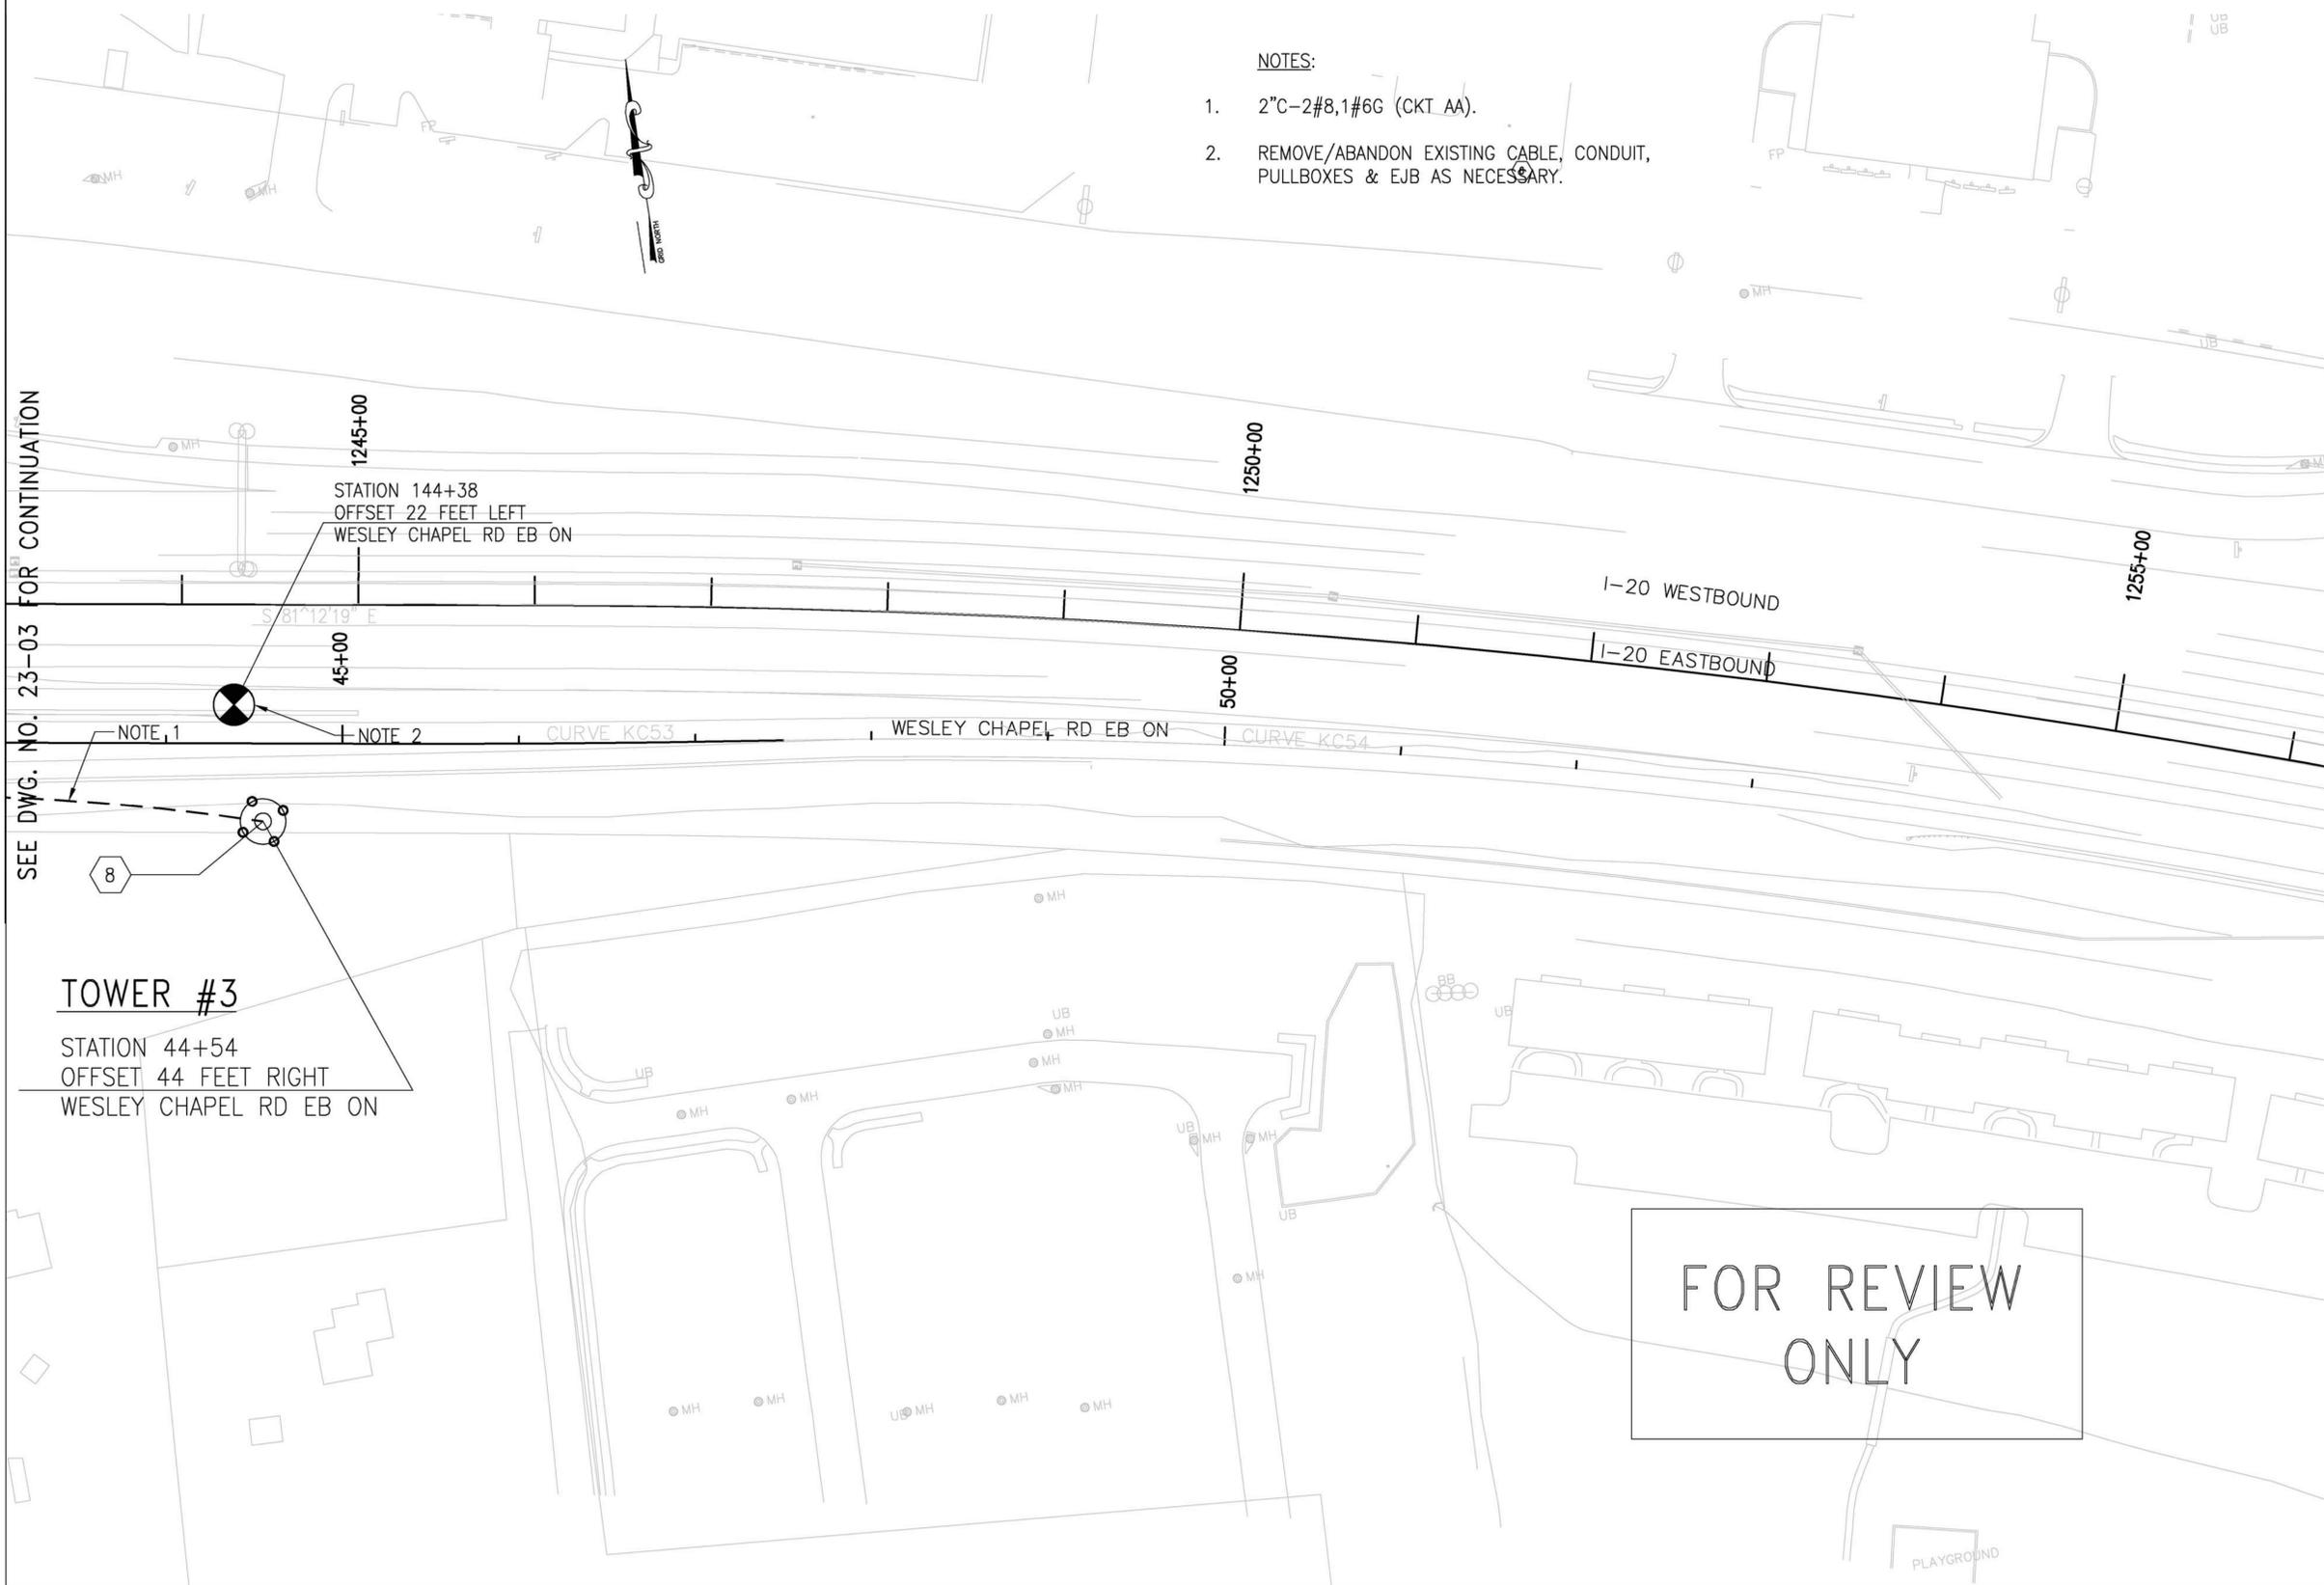

- NOTES:
- 2" C-2#8, 1#6G (CKT AA).
 - REMOVE/ABANDON EXISTING CABLE, CONDUIT, PULLBOXES & EJB AS NECESSARY.

STATION 144+38
OFFSET 22 FEET LEFT
WESLEY CHAPEL RD EB ON

 
TOWER #3
STATION 44+54
OFFSET 44 FEET RIGHT
WESLEY CHAPEL RD EB ON

FOR REVIEW ONLY

© 2011
ATLANTA CONSULTING ENGINEERS, INC.
ALL RIGHTS RESERVED.
THESE CONSTRUCTION DOCUMENTS
AND PERMITTED REPRODUCTIONS, IN
WHOLE OR IN PART, ARE INSTRUMENTS OF
SERVICE AND ARE THE SOLE PROPERTY
OF ATLANTA CONSULTING ENGINEERS, INC.
UNLESS OTHERWISE AGREED TO BY THE
OWNER. THEY SHALL NOT BE REPRODUCED OR CONVEYED
IN ANY MANNER NOR ARE THEY TO BE
USED FOR ANY OTHER PROJECTS OTHER
THAN THAT SPECIFICALLY INDICATED HEREIN
WITHOUT WRITTEN PERMISSION FROM AND
THE COMPENSATION TO ATLANTA
CONSULTING ENGINEERS, INC.

**ATLANTA
CONSULTING
ENGINEERS**
500 SUN VALLEY DRIVE
UNIT G2
ROSWELL, GEORGIA 30076
bal@atlconsengrs.com
Tel: 678-205-2240
Fax: 678-205-2239

THE LPA GROUP
TRANSPORTATION CONSULTANTS
A UNIT OF MICHAEL BAKER CORPORATION
3595 ENGINEERING DRIVE
NORCROSS, GEORGIA 30092
(770) 263-9118



REVISION DATES

STATE OF GEORGIA
DEPARTMENT OF TRANSPORTATION
OFFICE: INNOVATIVE PROGRAM DELIVERY
LIGHTING PLANS

LIGHTING PLAN

DRAWING No.
25-004