



WIRING SCHEDULE

- 1 3#12 IN 1" RIGID STEEL C.
- 2 1#6G IN 3/4" PVC C.
- 3 #6
- 4 2#8 + 1#8G IN 2" RIGID STEEL C ABOVE GRADE AND 2" PVC C BELOW GRADE.
- 5 4#8 + 1#8G IN 2" RIGID STEEL C ABOVE GRADE AND 2" PVC C BELOW GRADE.
- 6 3#10 IN 1" RIGID STEEL C.
- 7 2#6 + 1#6G IN 2" RIGID STEEL C ABOVE GRADE AND 2" PVC C BELOW GRADE.


ALL CONDUCTORS ARE TO BE COPPER

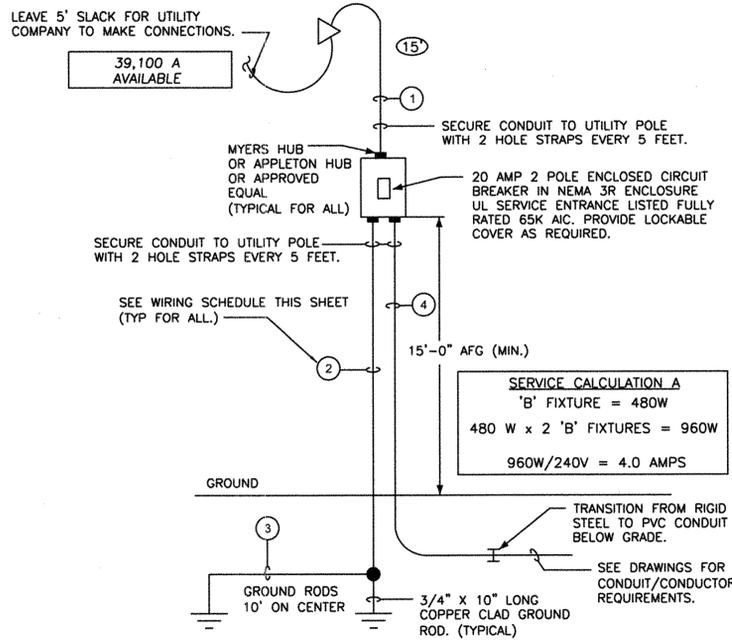


1 ONE LINE DIAGRAM SERVICE 'A'
25-06 SCALE: NTS

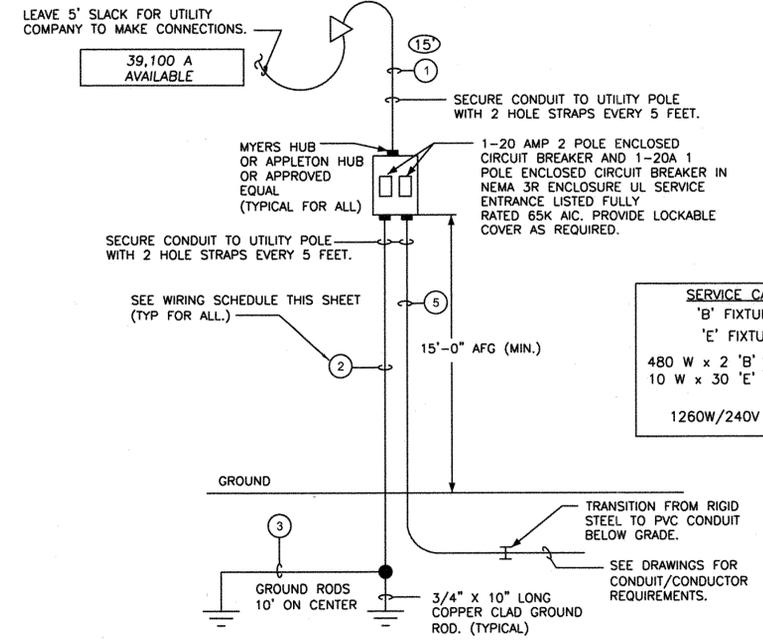

2 ONE LINE DIAGRAM SERVICE 'B'
25-06 SCALE: NTS

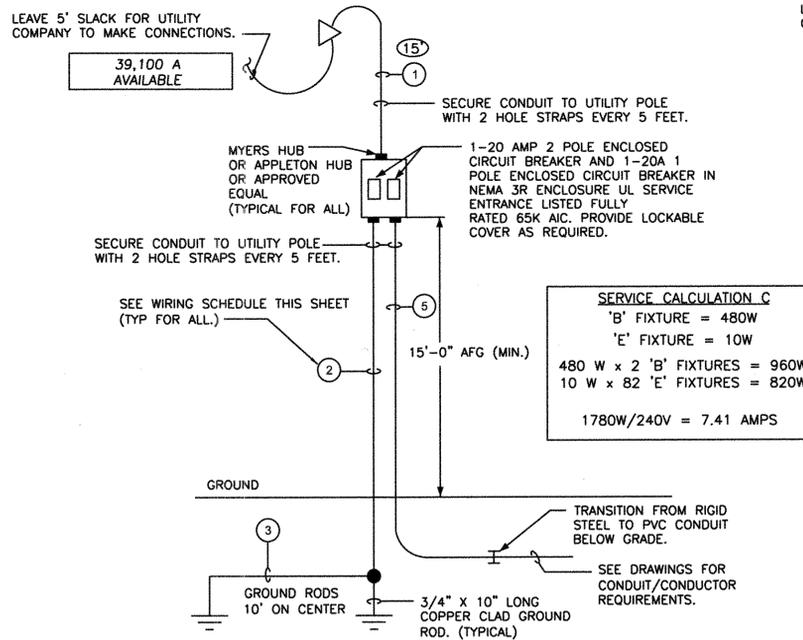

3 ONE LINE DIAGRAM SERVICE 'C'
25-06 SCALE: NTS

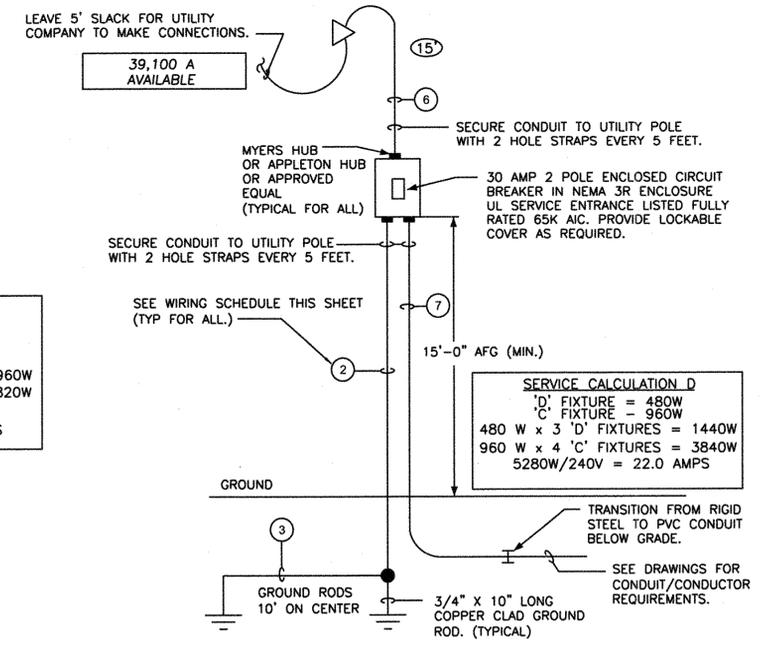

4 ONE LINE DIAGRAM SERVICE 'D'
25-06 SCALE: NTS

PROPERTY AND EXISTING R/W LINE
 REQUIRED R/W LINE
 CONSTRUCTION LIMITS
 EASEMENT FOR CONSTR
 & MAINTENANCE OF SLOPES
 EASEMENT FOR CONSTR OF SLOPES
 EASEMENT FOR CONSTR OF DRIVES

BEGIN LIMIT OF ACCESS.....BLA
 END LIMIT OF ACCESS.....ELA
 LIMIT OF ACCESS
 REQ'D. R/W AND LIMIT OF ACCESS

MA MORELAND-ALTOBELLI ASSOC., INC.
 (770) 263-5945

DESIGNED BY: GPG
 DRAWN BY: GPG
 CHECKED BY:
 SUPERVISED BY:

REVISION DATES	

STATE OF GEORGIA
 DEPARTMENT OF TRANSPORTATION

OFFICE:
DETAILS
 ASHFORD DUNWOODY ROAD
 BEGIN PROJECT TO STA. 17+50

DRAWING No.
25-06

W&A PROJECT NUMBER - 10088

4200 Perimeter Park South, Suite 225
 Atlanta, Georgia 30341
 Voice 770-458-3005 Fax 770-458-8388
 PLOT SCALE: 1 = 1