


END 45+33.68
CONSTRUCTION
C&G RT
RAMP 'D'

INTERSTATE 285
(VARIABLE R/W)

NOTES:


- 2" SCH 40 PVC 2#8 (CKT 2), 1#10G.

RELEASED FOR CONSTRUCTION 03/08/2016

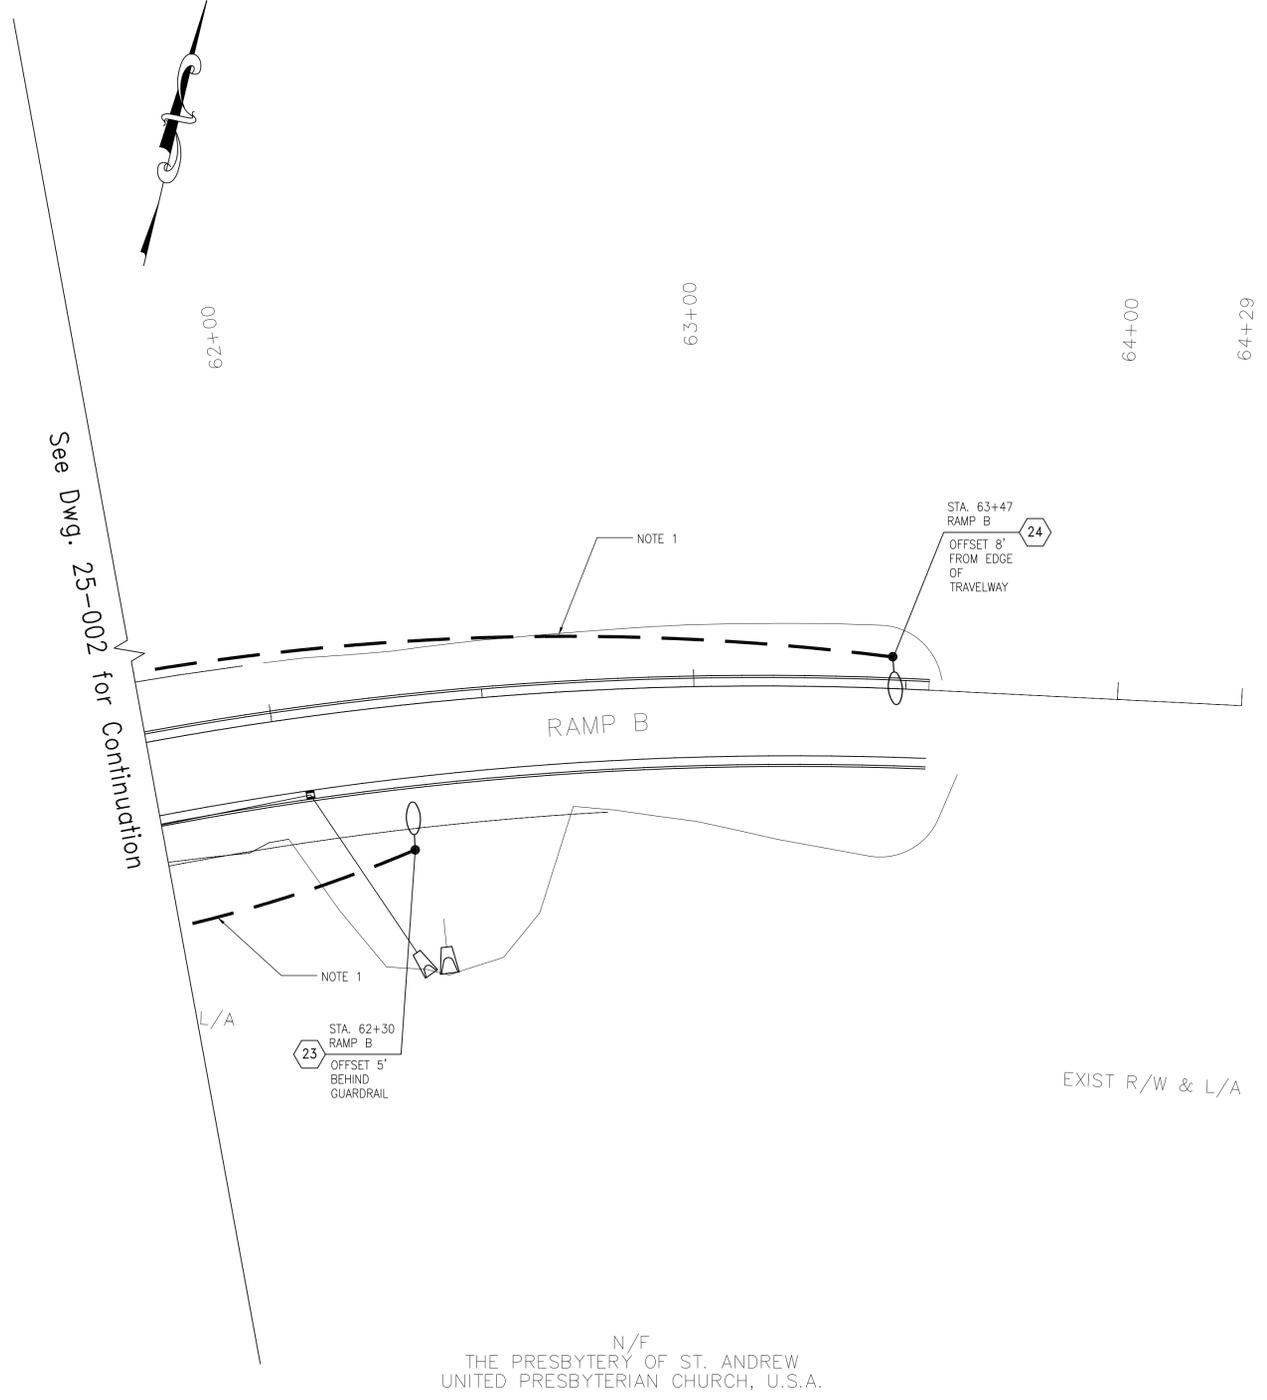

© 2015
ATLANTA CONSULTING ENGINEERS, INC.
ALL RIGHTS RESERVED

ATLANTA CONSULTING ENGINEERS
500 SUN VALLEY DRIVE
UNIT G2
ROSWELL, GEORGIA 30076
ba@atconsengrs.com
Tel: 678-205-2240
Fax: 678-205-2239

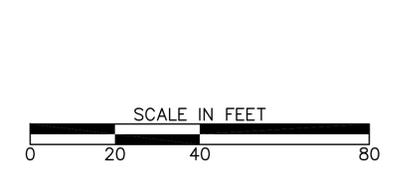

INFRASTRUCTURE CONSULTING & ENGINEERING

REVISION DATES	

STATE OF GEORGIA
DEPARTMENT OF TRANSPORTATION
OFFICE: INNOVATIVE DELIVERY

Lighting Layout

Riverside Drive at I-285
Interchange Improvements

DRAWING No.
25-006