


DATE/TIME*** \$USER**	TIME*** \$PRF*	\$PENTABLE**	\$DGN*	STATE GA	PROJECT NUMBER STP00-0032-02(028)	TOTAL SHEETS 1133
--------------------------	-------------------	--------------	--------	-------------	--------------------------------------	----------------------

- CONSTRUCTION - SEQUENCE OF OPERATIONS**
1. ERECT ALL CONSTRUCTION TRAFFIC CONTROL DEVICES AS REQUIRED IN SECTION 150 AND LATEST EDITION OF MUTCD.
  2. CONSTRUCT S. R. 133 BY WIDENING THE AREA AS SHOWN TO FINAL GRADE; INCLUDING DRAINAGE STRUCTURES. THEN CONSTRUCT S. R. 133 TO FINAL GRADE UNDER TRAFFIC WITH MULTIPLE LIFTS TO FINAL GRADE; INCLUDING DITCHES, SHOULDERS, SLOPES, CURB & GUTTER, SIDEWALK, PAVEMENT, AND GUARDRAIL, IF APPLICABLE.
  3. CONTRACTOR TO PROVIDE INGRESS AND EGRESS TO ALL EXISTING DRIVEWAYS AND SIDE ROADS FOR THE DURATION OF CONSTRUCTION, UNLESS OTHERWISE NOTED ON THE PLANS.

MATCH LINE STA 120+00 SEE DRAWING NO. 19-004

MATCH LINE STA 125+50 SEE DRAWING NO. 19-006

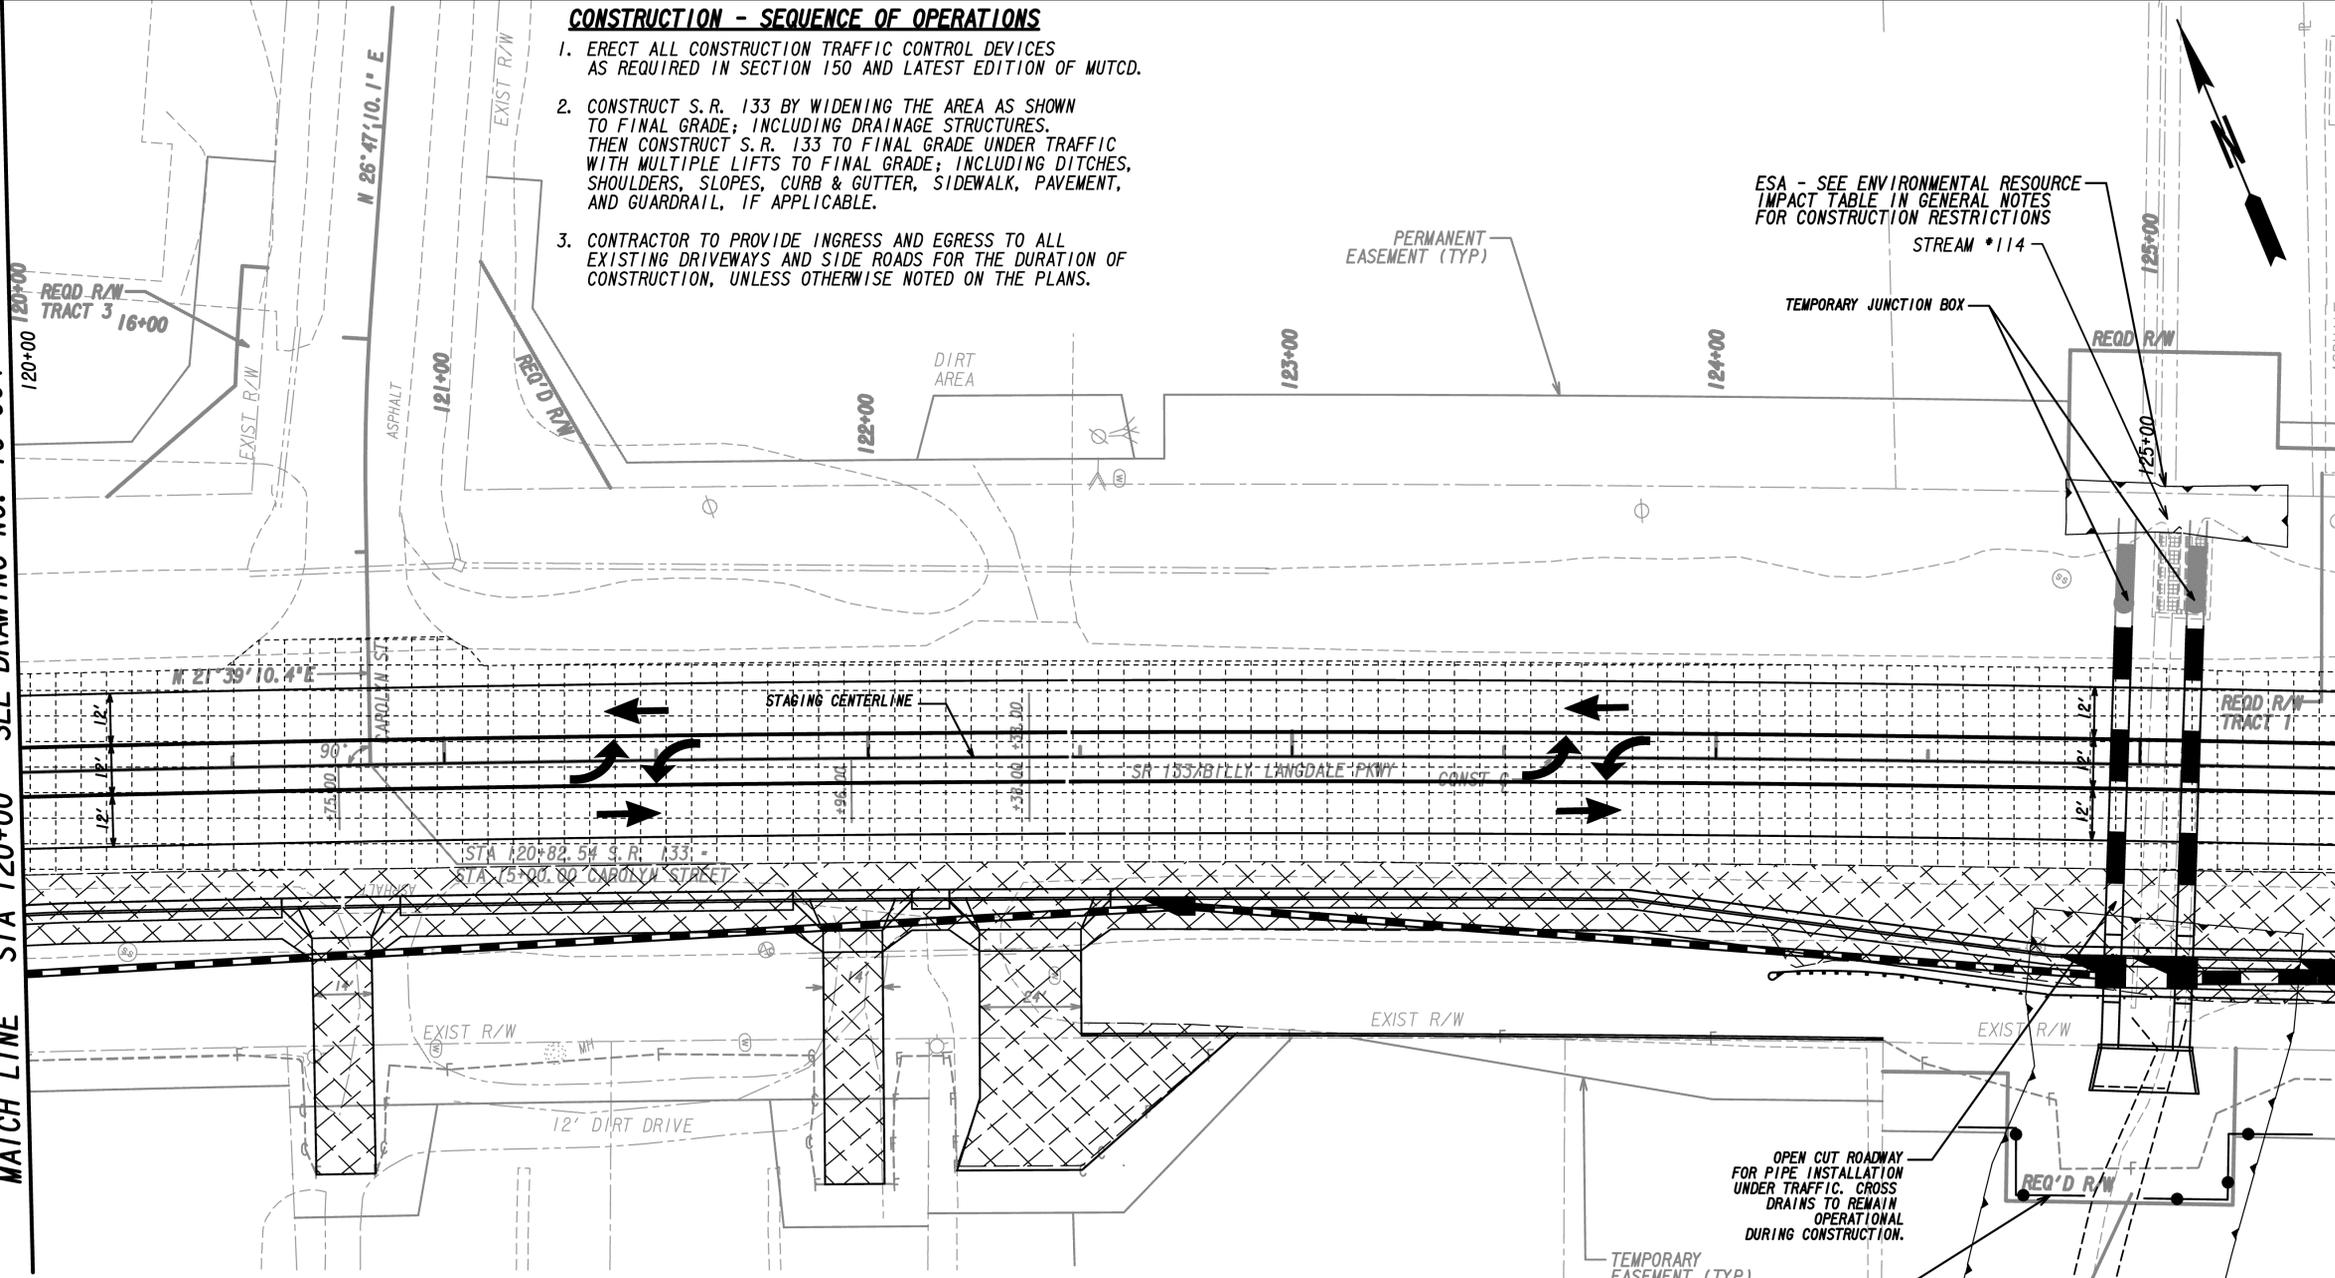

**SEQUENCE OF CONSTRUCTION (STAGE 1)**

1. CONSTRUCT ROADWAY PER FINAL CONSTRUCTION PLANS ON PROPOSED S. R. 133 RIGHT, AS SHOWN.
2. TRAFFIC TO REMAIN ON EXISTING PAVEMENT AS SHOWN.
3. OVERLAY ON S. R. 135 AS SHOWN IN PLANS, WHILE MAINTAINING TRAFFIC.
4. CONSTRUCT DRIVEWAYS TO FINAL GRADE AT STATION 120+75.00 RT, 121+96.00 RT, & 122+38.00 RT.
4. CONTRACTOR TO MAINTAIN TRAFFIC ON EXISTING S. R. 133 DURING CONSTRUCTION. TEMPORARY WIDENING ON THE SHOULDER MAY BE USED IF NECESSARY, TO MAINTAIN A MINIMUM OF THREE 11' LANES ON S. R. 133 AT ALL TIMES, EXCEPT WHERE NOTED IN PLANS.
5. DURING CONSTRUCTION, THE SPEED LIMIT SHALL BE REDUCED TO 35 M. P. H. FOR S. R. 133 WITHIN PROJECT CORRIDOR.
6. POSITIVE AND ADEQUATE DRAINAGE TO BE MAINTAINED AT ALL TIMES.
7. SEE GEORGIA DEPARTMENT OF TRANSPORTATION STANDARD 9100 TRAFFIC CONTROL GENERAL NOTES, STANDARD LEGEND, MISCELLANEOUS DETAILS.

**LEGEND**


PAVEMENT REMOVAL	
TEMPORARY CONSTRUCTION PAVEMENT	
PERMANENT CONSTRUCTION	

**LEGEND**

CONCRETE MEDIUM CONSTRUCTION	
MILL & OVERLAY CONSTRUCTION	
OPEN LANES OF TRAFFIC	

**Columbia Engineering**  
LAND PLANNERS - CIVIL ENGINEERS - LANDSCAPE ARCHITECTS - SURVEYORS

2763 Meadow Church Road, Suite 100  
 Duluth, GA 30097-4989  
 Phone: (770) 925-0357  
 Fax: (770) 925-0565

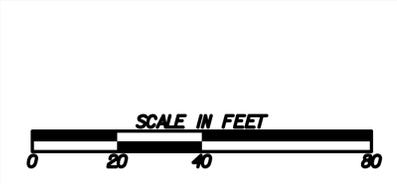

**REVISION DATES**


STATE OF GEORGIA  
 DEPARTMENT OF TRANSPORTATION  
 OFFICE: PROGRAM DELIVERY

**CONSTRUCTION STAGING PLAN**  
**STAGE 1**

SR133 FM SPENCE FLD TO SR35  
 COLQUITT COUNTY

DRAWING NO.  
**19-005**